


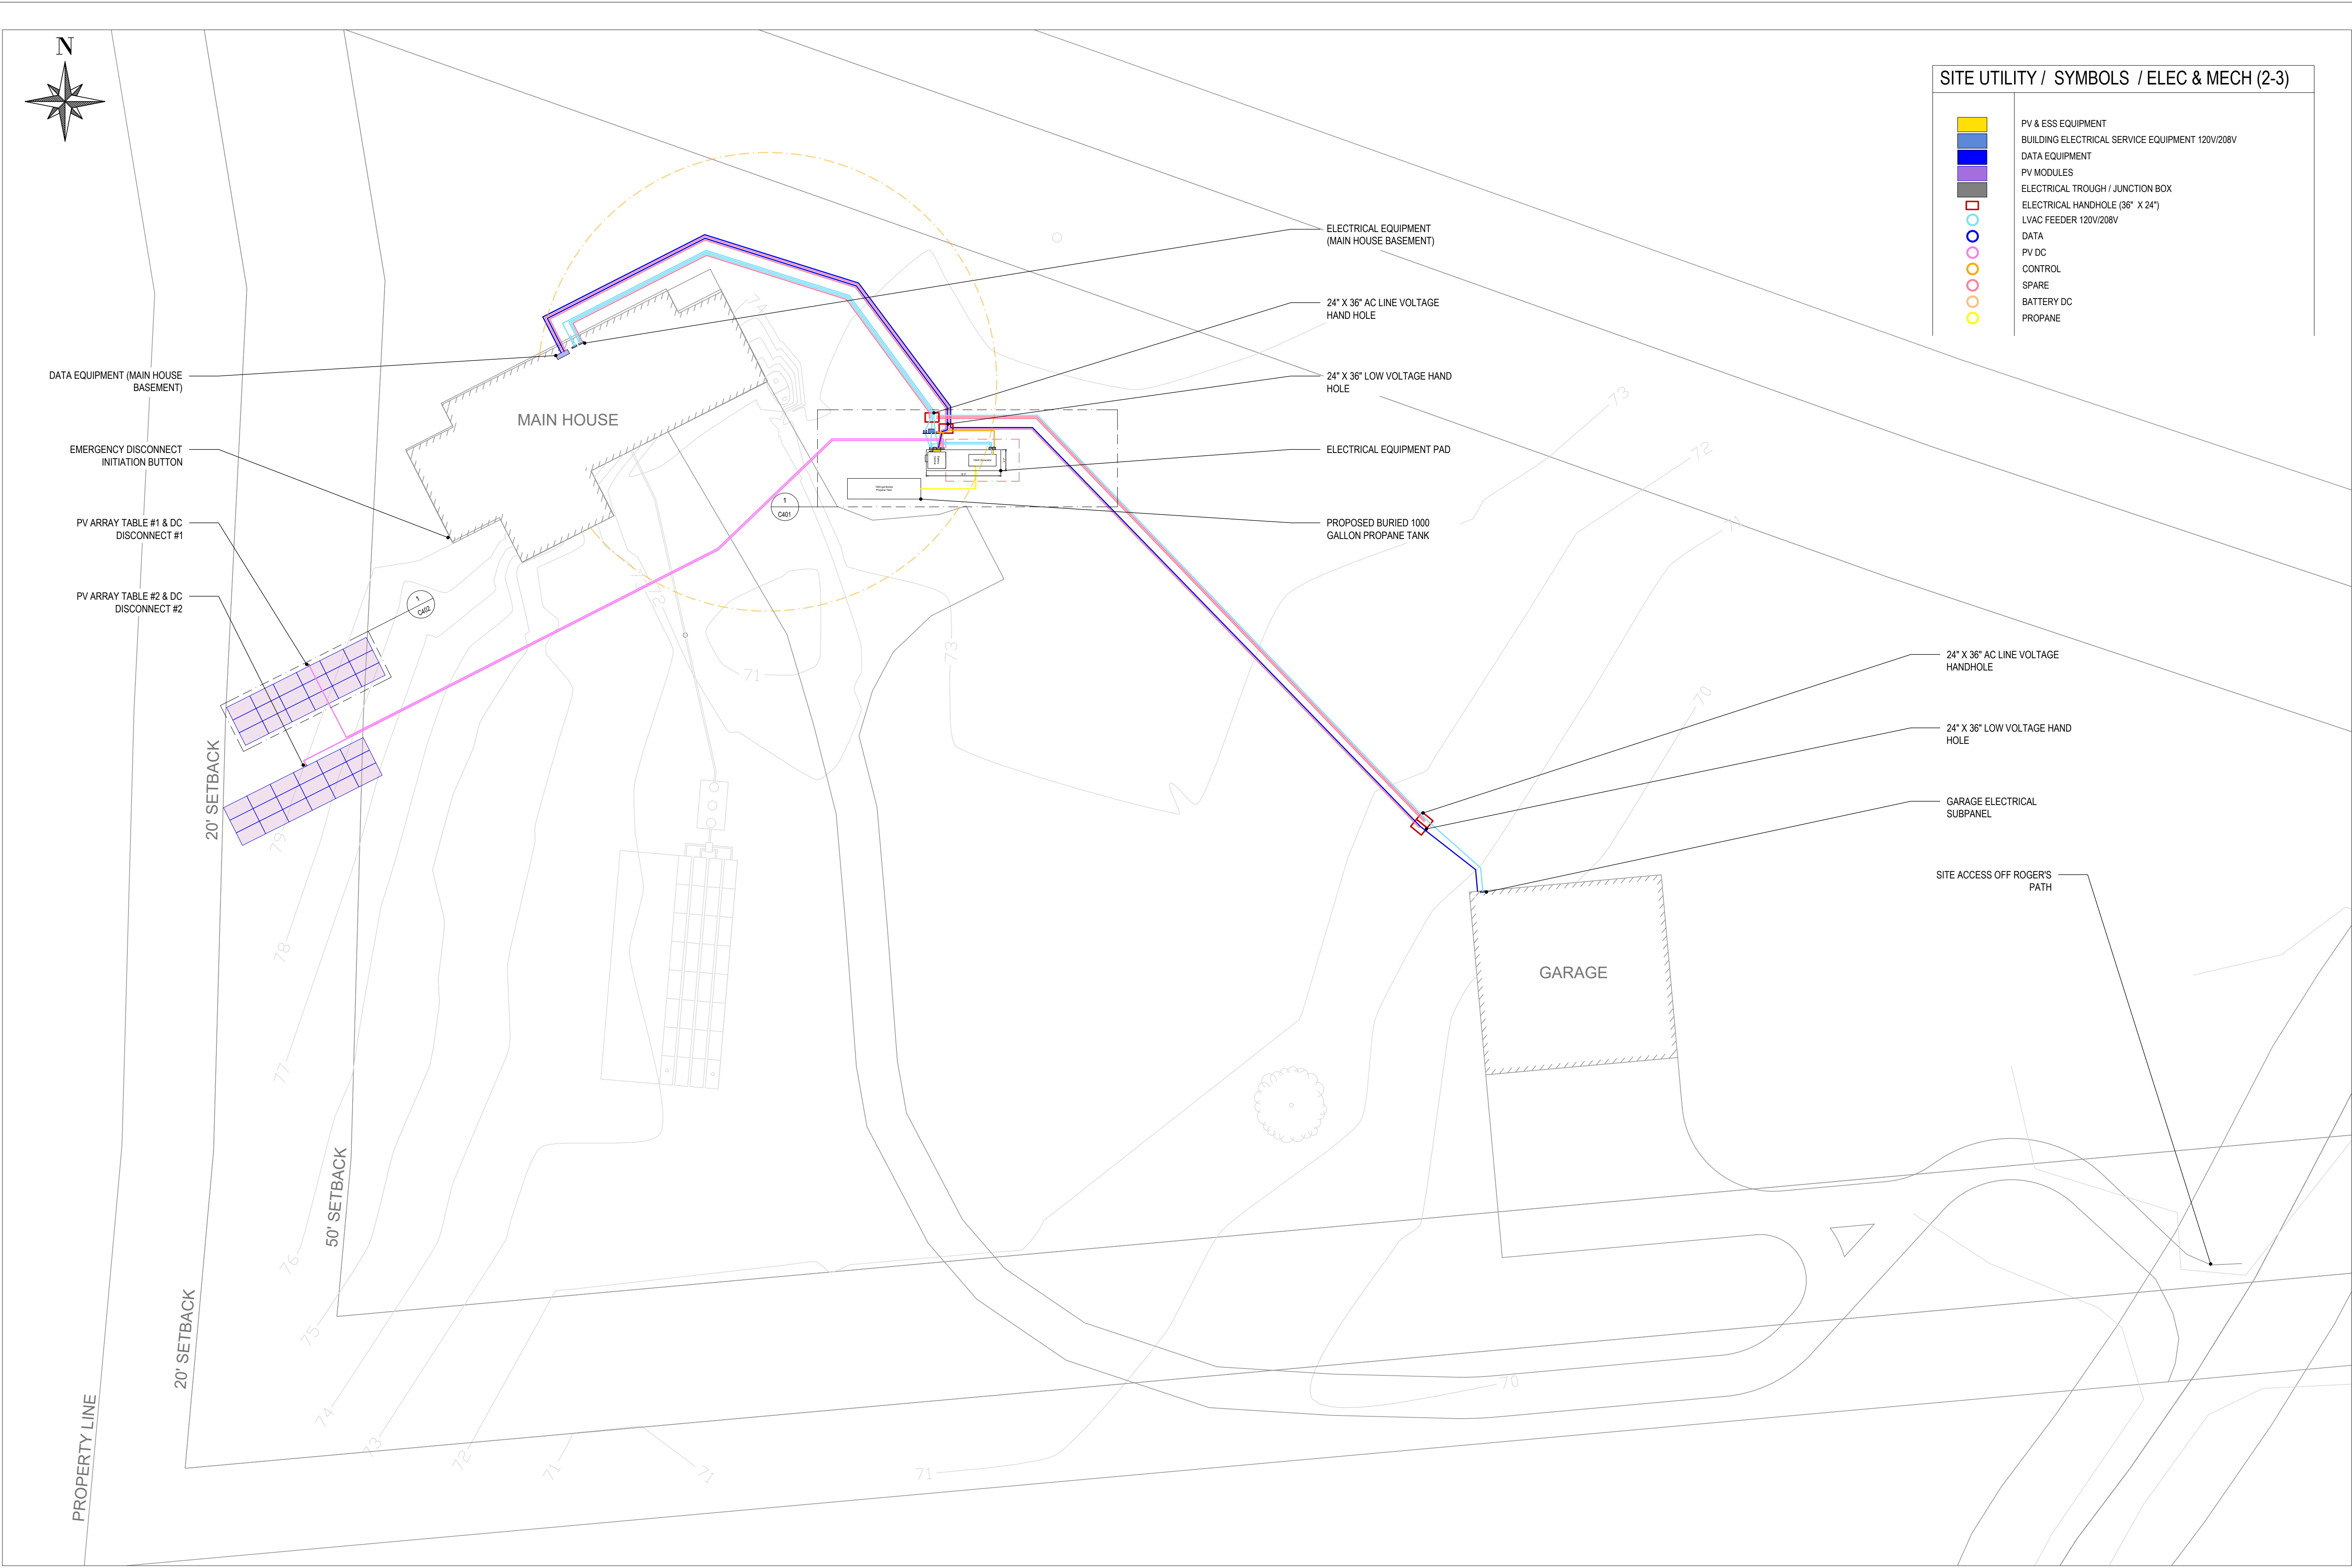

SITE UTILITY / SYMBOLS / ELEC & MECH (2-3)

- PV & ESS EQUIPMENT
- BUILDING ELECTRICAL SERVICE EQUIPMENT 120V/208V
- DATA EQUIPMENT
- PV MODULES
- ELECTRICAL TROUGH / JUNCTION BOX
- ELECTRICAL HANDHOLE (36" X 24")
- LVAC FEEDER 120V/208V
- DATA
- PV DC
- CONTROL
- SPARE
- BATTERY DC
- PROPANE

SITE UTILITY PLAN  
72 ROGERS PATH OFF-GRID DESIGN  
72 ROGERS PATH, WEST TISBURY, MA 02575

PERMIT

| REV | DESCRIPTION | DATE |
|-----|-------------|------|
|     |             |      |
|     |             |      |
C201

SCALE: 1/16" = 1'-0"  
DATE: 10/22/26

